

**Attachment # 1**  
**Application Packet with Plans**



# City of Clearlake

14050 Olympic Drive, Clearlake, California 95422  
(707) 994-8201 Fax (707) 995-2653

### INITIAL FEES:

Permit

CEQA

Receipt #

Received By

Date

(Please type or print)

## Planning Application

Type: CEQA

Project Name: Dollar General - Clearlake, CA

Assessor's Parcel #: 040-340-050 & 040-340-060

### APPLICANT:

NAME: John Wojtila

MAILING ADDRESS: 14600 Detroit Avenue, STE 1500

CITY: Lakewood

STATE: Ohio

ZIP: 44107

PRIMARY PHONE: (216) 226-5160

EMAIL: jwojtila@zarembagroup.com

SIGNATURE: *John M. Wojtila*

I declare under penalty of perjury that I am the owner of said property or have written authority from property owner to file this application. I certify that all of the submitted information is true and correct to the best of my knowledge and belief. I understand that any misrepresentation of submitted data may invalidate any approval of this application

### PROPERTY OWNER (IF NOT APPLICANT):

NAME: John Cutrufelli

MAILING ADDRESS: 40 TRINITY DR

CITY: Nevada,

STATE: CA

ZIP: 94947

PRIMARY PHONE: (415) 798-1629

EMAIL: JCUTRU3811@AOL.COM

SIGNATURE: *John Cutrufelli*

I declare under penalty of perjury that I am the owner of said property or have written authority from property owner to file this application. I certify that all of the submitted information is true and correct to the best of my knowledge and belief. I understand that any misrepresentation of submitted data may invalidate any approval of this application

### PROJECT LOCATION:

ADDRESS: 5330 Old Highway 53 & 5345 Jones Avenue

PROPERTY SIZE: +/- 1.09 acres

PRESENT USE OF LAND: C2 - Vacant

WATER SUPPLY: Highlands Water District

SEWER/SEPTIC: County of Lake - Utility Area 1

FLOOD ZONE: Unshaded Zone X, area of minimal flood hazard

### OFFICE ONLY:

ZONING: \_\_\_\_\_

GENERAL PLAN: \_\_\_\_\_

APPROVED: \_\_\_\_\_

DATE: \_\_\_\_\_

RELATED FILES: \_\_\_\_\_



NOTES: \_\_\_\_\_

### DESCRIPTION OF PROJECT:

Construction of a +/- 10,800 square foot retail store with associated site improvements and infrastructure.



2 DAYS BEFORE  
YOU DIG CALL USA  
TOLL FREE 1-800-227-2600

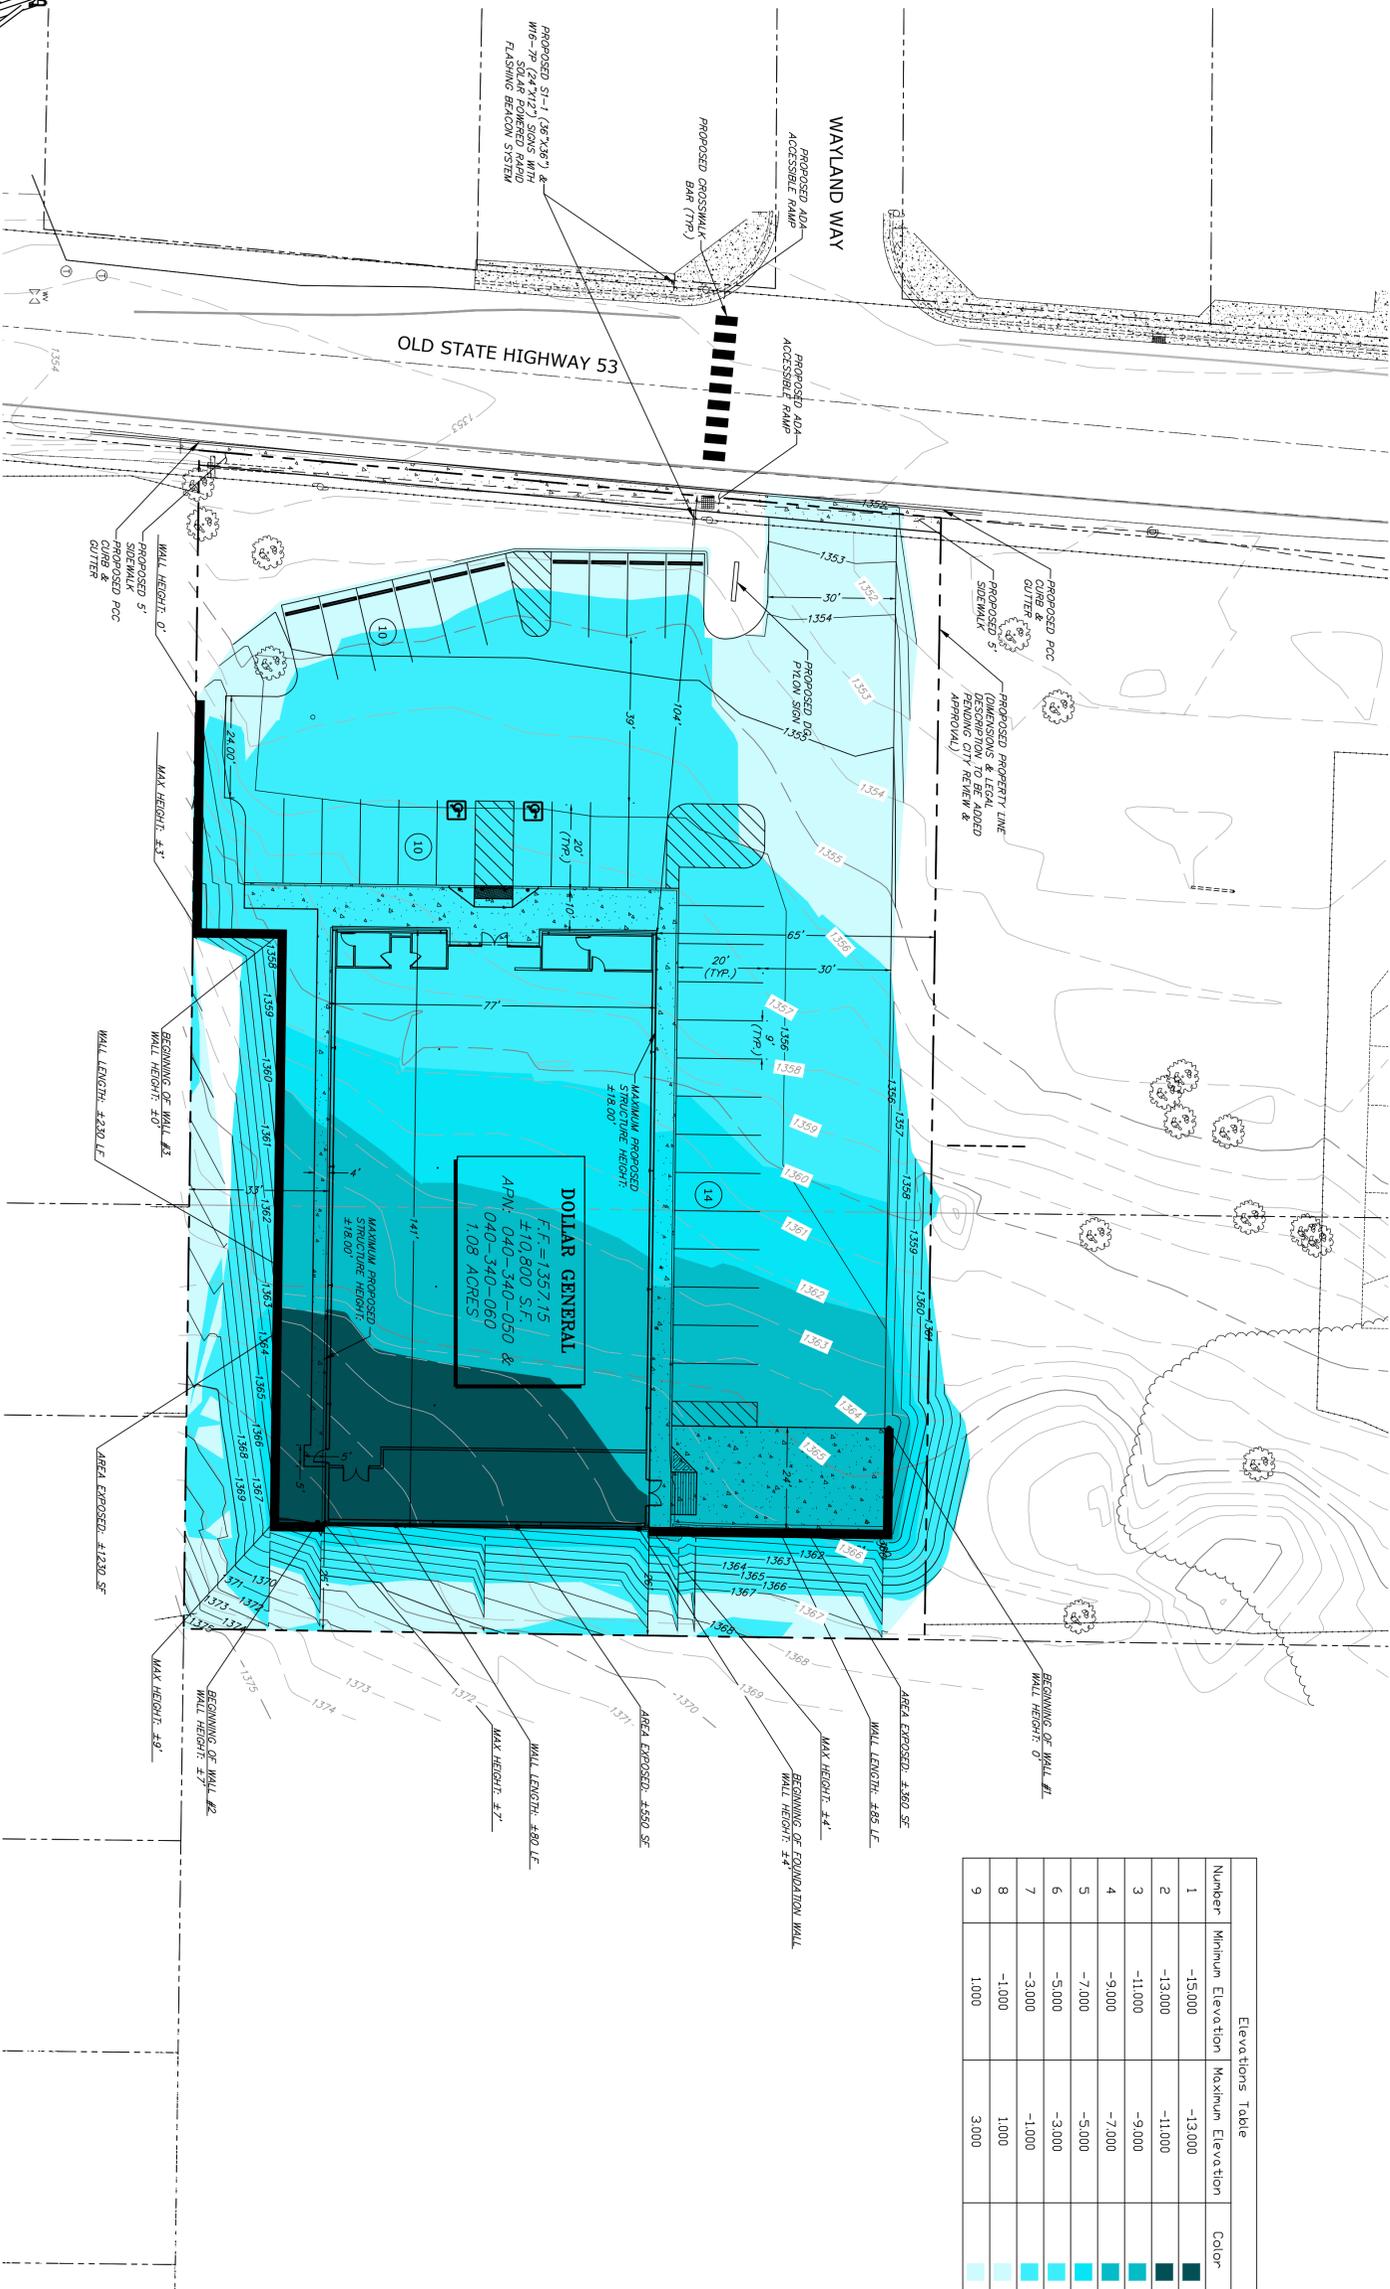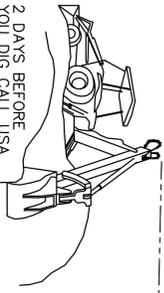

Elevations Table

Number	Minimum Elevation	Maximum Elevation	Color
1	-15.000	-13.000	Dark Blue
2	-13.000	-11.000	Medium Blue
3	-11.000	-9.000	Light Blue
4	-9.000	-7.000	Very Light Blue
5	-7.000	-5.000	Lightest Blue
6	-5.000	-3.000	White
7	-3.000	-1.000	White
8	-1.000	1.000	White
9	1.000	3.000	White

**DOLLAR GENERAL**  
 F.F. = 135715  
 F.F. 10,800 S.F.  
 APN: 040-340-050 &  
 040-340-060  
 1.08 ACRES

GRADING EXHIBIT

SCALE: N.T.S.



SHEET: EXH SHEET TITLE: GRADING EXHIBIT	SUBMITTAL RECORD: DATE: 01/10/22 SUBMITTAL	PROJECT/CLIENT: #: 20094 <p style="text-align: center;"><b>DOLLAR GENERAL</b>                  5330 OLD HWY 53 &amp; 5345 JONES AVE, CLEARLAKE, CA</p> <p style="text-align: center;"><b>ZAREMBA GROUP</b>                  14600 DETROIT AVE. CLEVELAND, OH 44107</p>	DESIGNER: <p style="font-size: small;">730 Sandhill Rd., #250, Reno, Nevada 89521                  www.tectonicsdesigngroup.com</p>	STAMP: <p style="text-align: center; font-size: large; font-weight: bold;">PRELIMINARY</p>	COPYRIGHT: <p style="font-size: x-small;">All drawings herein are the property of Tectonics Design Group and may not be reproduced or used in any capacity without the written authorization of Tectonics Design Group.</p> <p style="font-size: x-small;">DRAWN: M.C.M.                  DESIGNED: J.P.B.                  CHECKED/STAMPED: JONATHAN P. BROWNING, P.E.</p>
--	--	--	--	---	--



# DOLLAR GENERAL

Clearlake, CA

**DOLLAR GENERAL**




www.gpdgroup.com  
1.800.955.4731


THE COLORS AND MATERIALS SHOWN IN THIS RENDERING ARE CLOSE APPROXIMATIONS AND NOT AN EXACT MATCH. RENDERING IS TO BE CONSIDERED FOR VISUAL DESIGN INTENT ONLY AND NOT FOR CONSTRUCTION.




**1 WEST ELEVATION**  
A-2 1/8" = 1'-0"

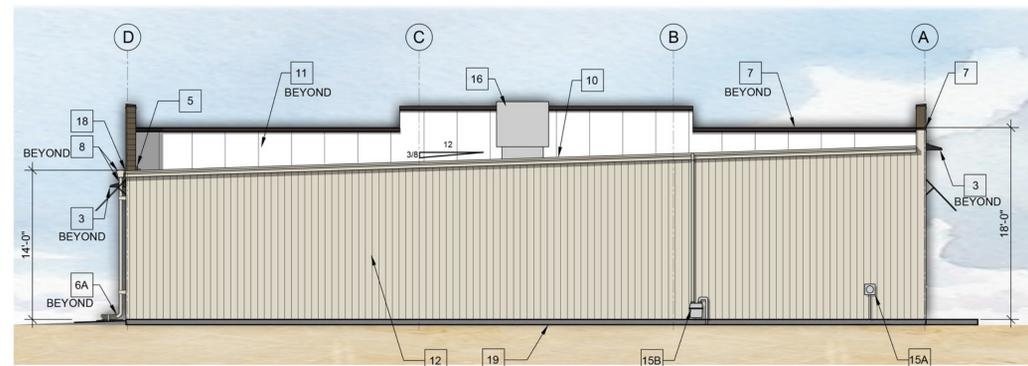

**2 EAST ELEVATION**  
A-2 1/8" = 1'-0"

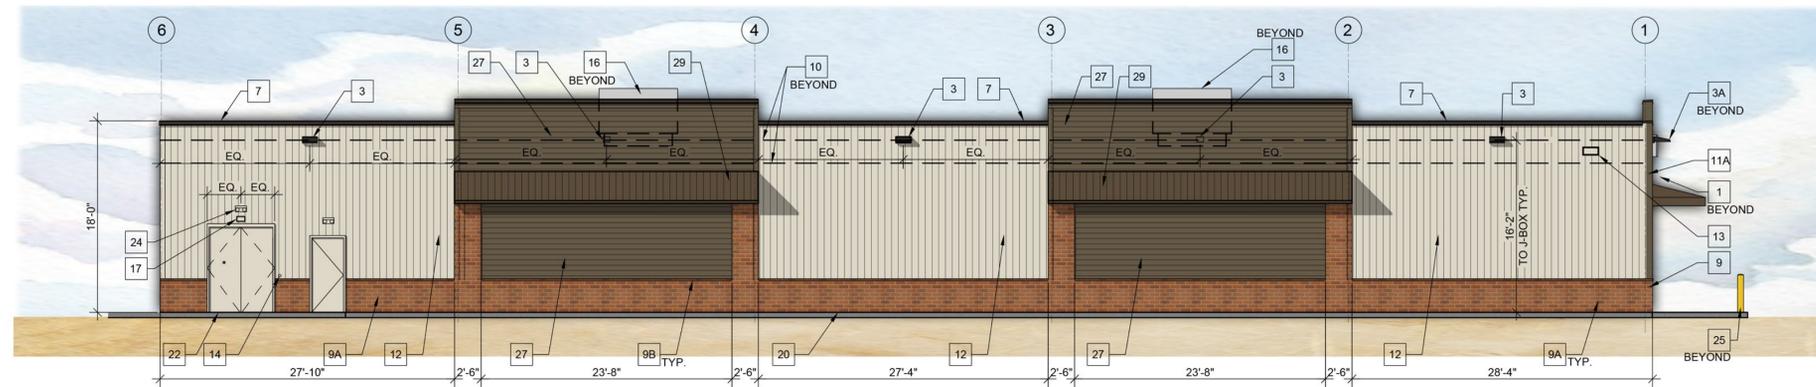

**3 NORTH ELEVATION (TRUCK SIDE)**  
A-2 1/8" = 1'-0"

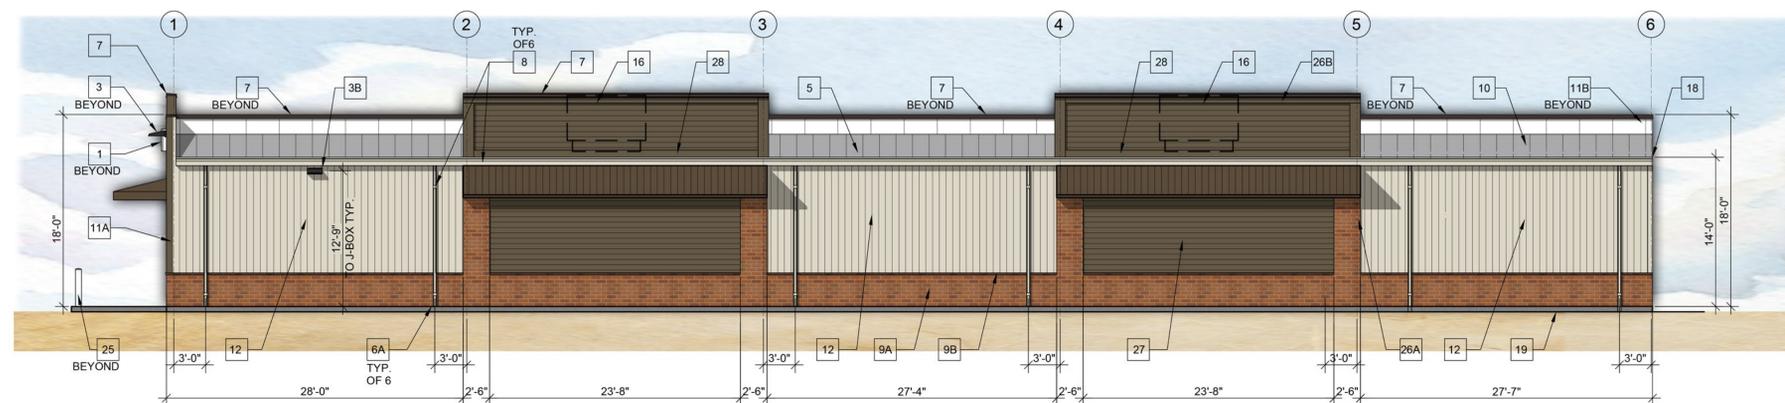

**4 SOUTH ELEVATION**  
A-2 1/8" = 1'-0"

**ELEVATION KEYED NOTES**

- 1 SIGN FURNISHED AND INSTALLED BY DOLLAR GENERAL CORP. WITH CIRCUIT AS NOTED ON ELECTRICAL PLAN. SIGN TO BE CENTERED ON FRONT OF BUILDING. CONTRACTOR IS TO PROVIDE ADEQUATE BLOCKING AS REQUIRED BY SIGN MANUFACTURER TO SUPPORT SIGN WEIGHT OF UP TO 1,400 LBS. EXTERIOR CANOPY SIGN SHALL BE SUPPORTED BY THE FACE OF THE CANOPY. COORDINATE THE PROPER SIGNAGE TO BE USED WITH DOLLAR GENERAL.
- 2 ADDRESS ABOVE DOOR MOUNTED ON CENTER PANE OF GLASS. ADDRESS TO BE 10'-12" VINYL CUT NUMBERS. COLOR: BLACK W/ WHITE OUTLINES.
- 3 LED WALL PACK FIXTURE. REFER TO ELECTRICAL SHEETS FOR ADDITIONAL INFORMATION.
- 4 A.D.A. COMPLIANT H.C. RAMP WITH YELLOW PAINTED SIDES TO H.C. PARKING STALLS. REFER TO CIVIL DRAWINGS FOR ADDITIONAL INFORMATION.
- 5 DYNA-GUARD SNOW RETENTION SYSTEM TO BE INSTALLED BY GENERAL CONTRACTOR. REFER TO MANUFACTURER'S INSTALLATION INSTRUCTIONS FOR ADDITIONAL INFORMATION.
- 6A 12" x 24" CONCRETE SPLASH BLOCK STRAPPED TO A 5' LONG, 6" PERFORATED LANDSCAPE PIPE. (TYP. OF 1)
- 6B THRU-SIDEWALK DOWNSPOUT. REFER TO CIVIL SHEETS FOR DETAILS. (TYP. OF 5)
- 7 METAL COPING / FLASHING / TRIM. REFER TO EXTERIOR FINISHES TABLE ON THIS SHEET FOR COLOR.
- 8 GUTTER AND DOWNSPOUT. PROVIDE ADEQUATE STRAPPING TO STRUCTURE. REFER TO EXTERIOR FINISHES TABLE ON THIS SHEET FOR COLOR.
- 9A NICHIIA- PLYMOUTH BRICK. REFER TO EXTERIOR FINISH TABLE THIS SHEET FOR COLOR.
- 9B NICHIIA- KURASTONE - CHISELED LEDGE STONE. REFER TO EXTERIOR FINISH TABLE THIS SHEET FOR COLOR.
- 10 STANDING SEAM METAL ROOF. REFER TO EXTERIOR FINISHES TABLE ON THIS SHEET FOR COLOR.
- 11 METAL PANEL. BACK SIDE OF PARAPET. REFER TO EXTERIOR FINISHES TABLE ON THIS SHEET FOR COLOR.
- 12 PRE-FINISHED METAL WALL PANELS (BY PEMB). PROVIDE TAMPER- RESISTANT FASTENERS UP TO 8'-0" A.F.F. REFER TO EXTERIOR FINISHES TABLE ON THIS SHEET FOR COLOR.
- 13 VENT FOR BATHROOM EXHAUST. REFER TO SHEET M-1 FOR ADDITIONAL INFORMATION.
- 14 DOOR BUZZER. REFER TO SHEET E-1 FOR ADDITIONAL INFORMATION.
- 15A ELECTRIC METER. REFER TO ELECTRICAL SHEETS FOR ADDITIONAL INFORMATION.
- 15B GAS METER. REFER TO PLUMBING SHEETS FOR ADDITIONAL INFORMATION.
- 16 HVAC UNITS MOUNTED ON ROOF. REFER TO SHEET M-1 FOR ADDITIONAL INFORMATION.
- 17 OUTSIDE AIR TEMP. SENSOR MOUNTED OVER RECEIVING DOORS @ 8'-0" A.F.F.
- 18 MINIMUM EAVE HEIGHT IS 14'-0" A.F.F.
- 19 FINISHED GRADE AT EXTERIOR WALLS SHALL BE A MINIMUM OF 6" BELOW FINISHED FLOOR AT ALL NON PAVED AREAS.
- 20 HARD SURFACE AT EXTERIOR WALLS SHALL BE A MINIMUM OF 2" BELOW FINISHED FLOOR AT PAVED AREAS.
- 21 1/2" DIAMETER x 8' LONG STAINLESS STEEL EYE BOLTS (CLOSED) WITH 1" DIAMETER OPENINGS. DRILL AND EPOXY INTO BLOCK WALL. 4 BOLTS TO BE LOCATED AS SHOWN EACH SIDE OF ENTRY. TOTAL OF 8 BOLTS.
- 22 SLOPE CONCRETE AT ENTRANCE AND EXIT LOCATION.
- 23 BRONZE STOREFRONT SYSTEM. REFER TO SHEET A-5 FOR ADDITIONAL INFORMATION.
- 24 EMERGENCY EXIT LIGHT. REFER TO ELECTRICAL SHEETS FOR ADDITIONAL INFORMATION.
- 25 6" BOLLARDS - CONCRETE FILLED, PAINTED YELLOW & PERMANENT PARKING SIGNAGE FOR HANDICAPPED SPACES AND VAN ACCESSIBLE SPACE. TO COMPLY WITH ADAAG 2010. SECTION 502.6. REFER TO CIVIL DRAWINGS FOR ADDITIONAL INFORMATION.
- 26A 5.5" (ACTUAL) HARDIE TRIM BOARD. REFER TO EXTERIOR FINISH TABLE ON THIS SHEET FOR COLOR. PROPERLY SECURE TO PLYWOOD SHEATHING
- 26B 11.25" (ACTUAL) HARDIE TRIM BOARD. REFER TO EXTERIOR FINISH TABLE ON THIS SHEET FOR COLOR. PROPERLY SECURE TO PLYWOOD SHEATHING
- 27 HARDIEPLANK LAP SIDING. STYLE: SMOOTH. WIDTH: 7.25". EXPOSURE: 6". PAINTED. REFER TO FINISH TABLE ON SHEET A-2 FOR ADDITIONAL INFORMATION. PROPERLY SECURE TO PLYWOOD SHEATHING.
- 28 8" PASS THROUGH PARAPET SCUPPER.
- 29 PRE-FABRICATED CANOPY BY GENERAL CONTRACTOR. REFER TO EXTERIOR FINISH TABLE ON THIS SHEET FOR COLOR.
- 30 METAL CANOPY BY PEMB. REFER TO EXTERIOR FINISH TABLE ON THIS SHEET FOR COLOR.

PRE-ENGINEERED METAL BUILDING VENDOR  
CHIEF BUILDINGS ATTN: ERIN SULLIVAN (308) 385-4628 (308) 390-8199

EXTERIOR FINISHES	PARCHMENT	ANTIQUE BRONZE	BRONZE	POLAR WHITE	GALVALUME
EXTERIOR FINISHES ARE TO MATCH OR BE EQUAL TO VP METAL BUILDING SYSTEMS FINISH SELECTION.					
GUTTERS AND DOWNSPOUTS (KEYNOTE #8)	•				
NICHIIA- PLYMOUTH BRICK. (KEYNOTE 9A).			CRIMSON		
NICHIIA - CHISELED LEDGE STONE (PAINTED). (KEYNOTE 9B).			CRIMSON		
STANDING SEAM METAL ROOF PANELS (KEYNOTE #10)					•
LINER PANELS (INTERIOR SALES AND RECEIVING FLOOR)				•	
FLAT METAL SOFFIT AT STOREFRONT VESTIBULE AREA				•	
METAL COPING (KEYNOTE #7 AND #11A)		•			
METAL PARAPET PANEL - BACK SIDE (KEYNOTE #11B)	•				
SIDE AND REAR METAL WALL PANELS & TRIM, RECEIVING & EMERGENCY EXIT DOORS (EXTERIOR OF DOORS TO BE PAINTED. REFER TO DOOR SCHEDULE) (KEYNOTE #12)	•				
STANLEY STOREFRONT SYSTEM (KEYNOTE #23)			•		
HARDIE-PANEL SMOOTH VINYL TRIM BOARD. (KEYNOTE #26A AND #26B)					TIMBER BARK
HARDIEPLANK LAP SIDING. STYLE: SMOOTH. (KEYNOTE #27)					TIMBER BARK
PRE-FABRICATED METAL CANOPY BY G.C. (KEYNOTE #29)					DARK BRONZE
METAL CANOPY BY PEMB. (KEYNOTE #30)					DARK BRONZE


**DOLLAR GENERAL**

Clearlake, CA



# DOLLAR GENERAL®

## ILLUMINATION VIEW

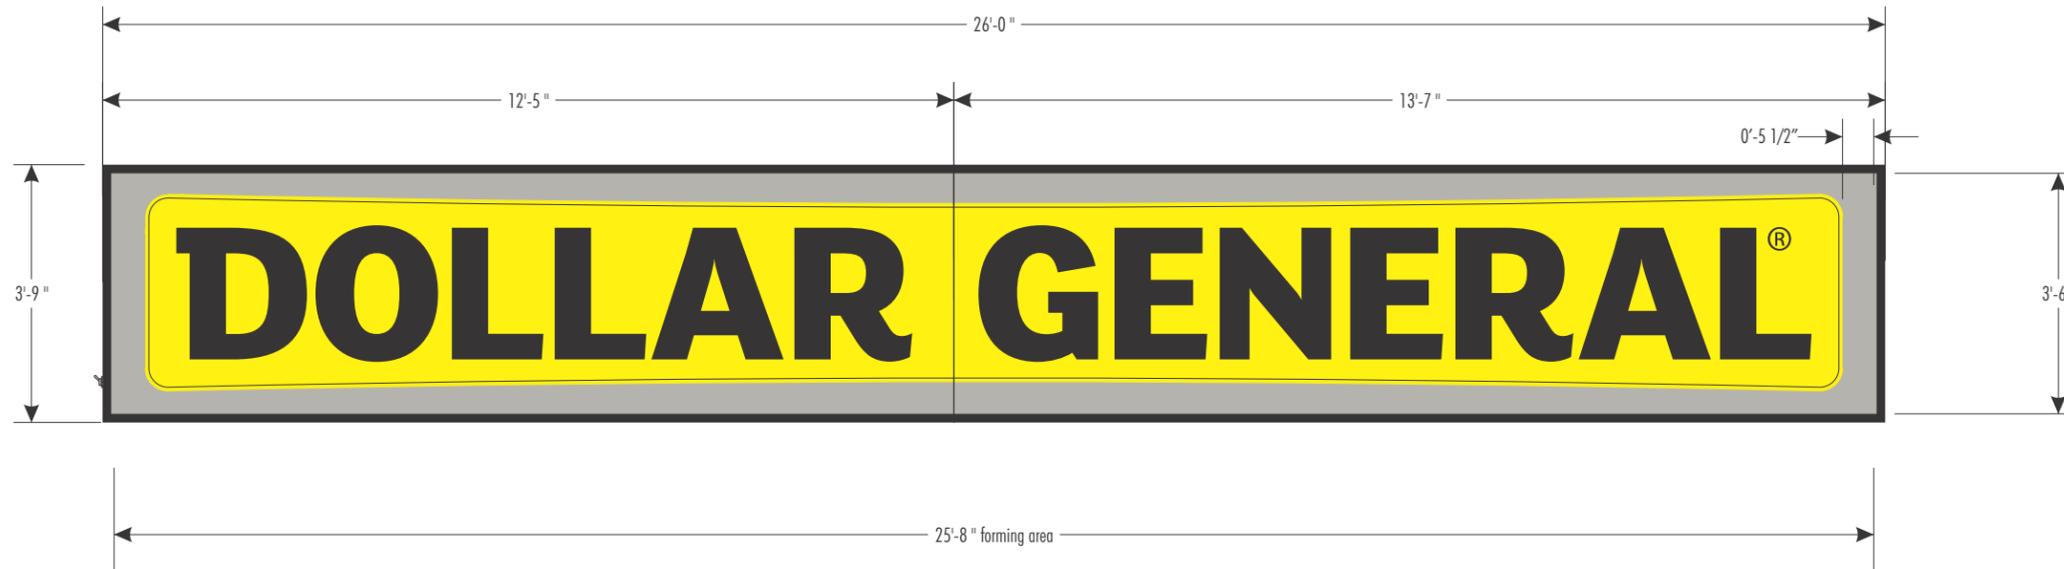

### REVISION HISTORY:

REV	DATE	REQUESTED BY	UPDATED BY
D	04/30/14		JM
REVISION DESCRIPTION UPDATED HOLE SIZE ON MOUNTING ANGLE			
B	08/16/13		SCP
REVISION DESCRIPTION REMOVED DUPLICATE COLOR CALLOUTS			
C	08/20/13		SCP
REVISION DESCRIPTION ADDED 2ND EMBOSSEMENT DETAIL			
D	05/31/16	C.R	M.M
REVISION DESCRIPTION REMOVED CAD DETAILS FROM PG 1			

### PARTS LIST:

ITEM	DECORATION
A	SPRAYLAT CB-2633 OR EQUIVALENT
E	SPRAYLAT BLACK OR EQUIVALENT
C	MATCH PMS COOL GRAY 5
D	METAL PAINT BLACK POLYURETHANE
E	
F	
MATERIAL LIST	
1	
2	
3	
4	
5	

**THIS SIGN IS INTENDED TO BE INSTALLED IN ACCORDANCE WITH THE REQUIREMENTS OF ARTICLE 600 OF THE NATIONAL ELECTRIC CODE AND/OR OTHER APPLICABLE LOCAL CODES. THIS INCLUDES PROPER GROUNDING AND BONDING OF THE SIGN**

### GENERAL NOTES

1. TOLERANCE ( UNLESS NOTED )  
• GRAPHICS +/- 1/8" • FACE SIZE + 1/16" - 1/4"  
• CABINET +/- 1/8" • VINYL OVERLAP + 1/8" +/- 1/16"  
• ALL COPY LEVEL UNLESS NOTED OTHERWISE
2. VIEWING DISTANCE 25' TO 50' UNLESS NOTED OTHERWISE
3. PMS COLOR CALLOUT INDICATES USE OF SPRAYLAT MIX SYSTEM
4. NO DEVIATION OR MATERIAL SUBSTITUTION WITHOUT ECN.
5. ALL ELECTRICAL SIGNS TO COMPLY WITH UL 48

DESCRIPTION			
DOLLAR GENERAL SF IL WALL CABINET 3'9" X 26' 140MPH			
VOLTAGE:	CIRCUIT:	CURRENT:	DESIGN LOAD:
12	(1)20	11.4	30 psf
DRAWN BY:	CHECKED BY:		
B.PERRY			
CLIENT: DOLLAR GENERAL			
LOCATION: VARIOUS			
QUOTE:	DATE:		
VARIOUS	07/08/13		
DRAWING/PART #	REV.	SHEET #	
DG0426W02	D	1 OF 4	

This document reflects trade secrets and confidential business information, and may not be copied, published, or disseminated in any manner without the prior express written approval of SignResource. All rights reserved, including patent.

APPROVAL SIGNATURE

DATE

By signing, you are validating the dimensions and graphic provided to SignResource and/or you are handling your own installation.

APPROVAL SIGNATURE

DATE

By signing, you are validating the dimensions and graphic provided to SignResource and/or you are handling your own installation.



6135 District Blvd • Maywood, CA 90270  
800.423.4283 • Fax 323.560.7143  
Website: www.signresource.com

REVISION HISTORY:

REV	DATE	REQUESTED BY	UPDATED BY
A	06/27/13		BP
REVISION DESCRIPTION INITIAL DRAWING RELEASE			
B	08/16/13		SCP
REVISION DESCRIPTION REMOVED DUPLICATE COLOR CALLOUTS			
C	08/20/13		SCP
REVISION DESCRIPTION ADDED 2ND EMBOSMENT DETAIL			

PARTS LIST:

ITEM	DECORATION
A	SPRAYLAT C8-2633 OR EQUIVALENT
B	SPRAYLAT BLACK OR EQUIVALENT
C	MATCH PMS COOL GRAY 5
D	METAL PAINT BLACK POLYURETHANE
E	
F	
MATERIAL LIST	
1	
2	
3	
4	
5	


THIS SIGN IS INTENDED TO BE INSTALLED IN ACCORDANCE WITH THE REQUIREMENTS OF ARTICLE 600 OF THE NATIONAL ELECTRIC CODE AND/OR OTHER APPLICABLE LOCAL CODES. THIS INCLUDES PROPER GROUNDING AND BONDING OF THE SIGN

GENERAL NOTES

- TOLERANCE (UNLESS NOTED)
  - GRAPHICS +/- 1/8" • FACE SIZE + 1/16" - 1/4"
  - CABINET +/- 1/8" • VINYL OVERLAP + 1/8" +/- 1/16"
  - ALL COPY LEVEL UNLESS NOTED OTHERWISE
- VIEWING DISTANCE 25' TO 50' UNLESS NOTED OTHERWISE
- PMS COLOR CALLOUT INDICATES USE OF SPRAYLAT MIX SYSTEM
- NO DEVIATION OR MATERIAL SUBSTITUTION WITHOUT ECN.
- ALL ELECTRICAL SIGNS TO COMPLY WITH UL 48

DESCRIPTION			
<b>DOLLAR GENERAL SF IL WALL CABINET 3'9" X 26' 140MPH</b>			
VOLTAGE:	CIRCUIT:	CURRENT:	DESIGN LOAD:
DRAWN BY: B.PERRY		CHECKED BY:	
CLIENT: DOLLAR GENERAL			
LOCATION: VARIOUS			
QUOTE: VARIOUS	DATE: 07/08/13		
DRAWING/PART # DGO426W02	REV. D	SHEET # 2 OF 4	

This document reflects trade secrets and confidential business information, and may not be copied, published, or disseminated in any manner without the prior express written approval of SignResource. All rights reserved, including patent.

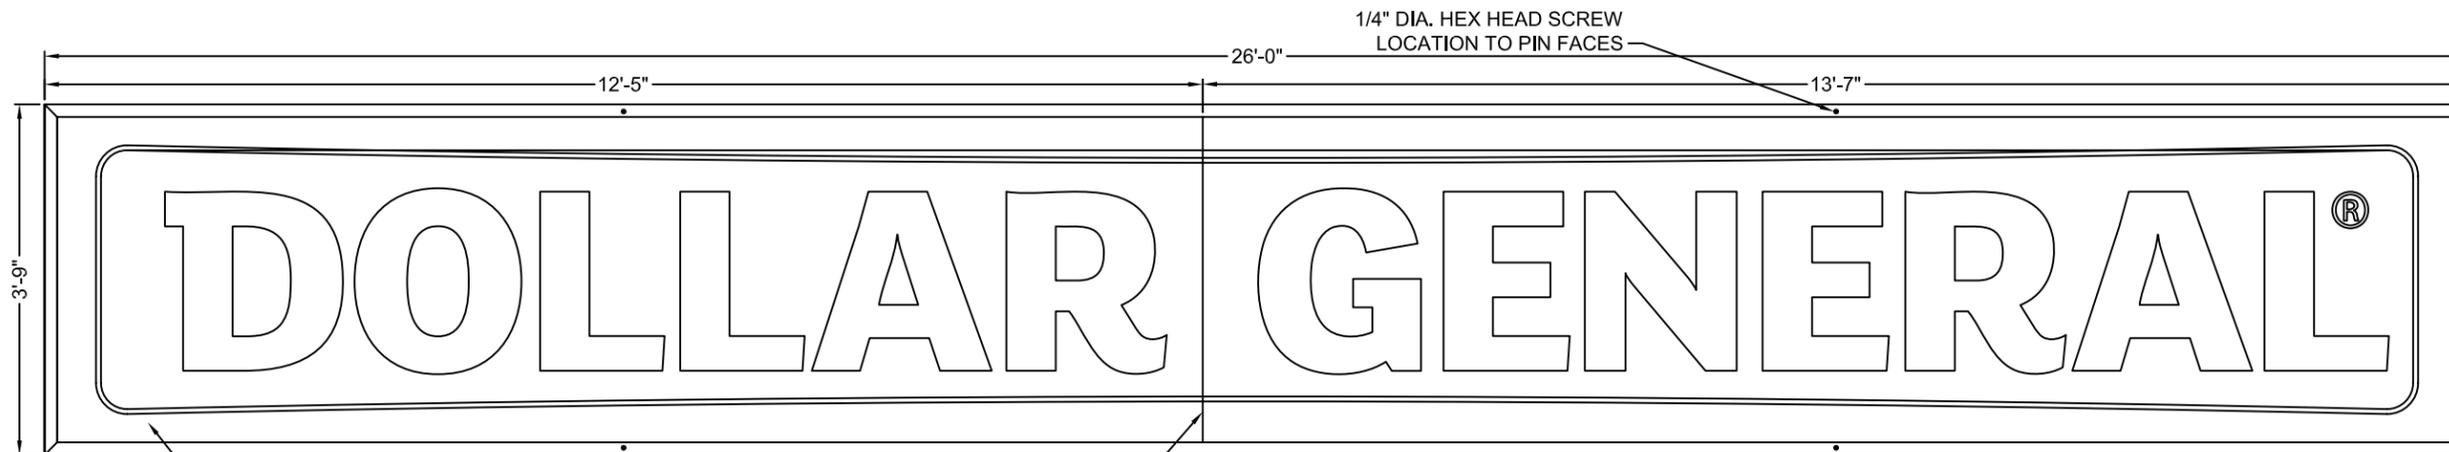


0.150" CLEAR UV POLYCARBONATE PAN FORMED FACE W/ BLACK COPY OVER SPRAYLAT C8-2633 YELLOW ON PMS COOL GRAY 5 BACKGROUND (SPECIAL COLOR APPROVED SCREEN PRINT)

FACE SEAM ELEVATION

GRAPHICS DEPICTED ON THIS DRAWING ARE FOR ILLUSTRATIVE PURPOSES ONLY. DO NOT USE THIS DRAWING FOR PRODUCTION ART, REFER TO PRODUCTION ELECTRONIC FILES

ALL EXPOSED FASTENER HEADS SHALL BE PAINTED TO MATCH THE EXTERIOR CABINET FINISH

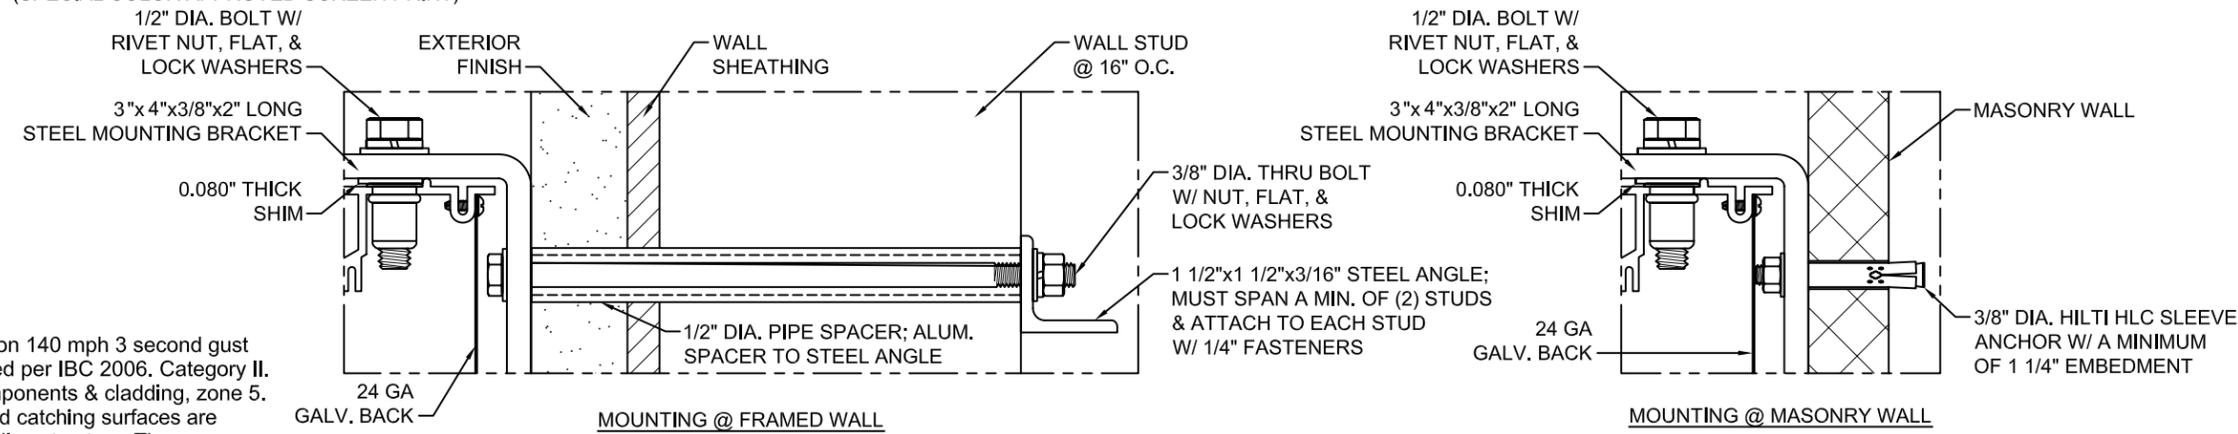

NOTES:

- Design is based on 140 mph 3 second gust design wind speed per IBC 2006, Category II, Exposure C, components & cladding, zone 5.
- No additional wind catching surfaces are added to the building structure. The customer's building engineer is to determine the adequacy of the supporting structure.
- Aluminum shall be fabricated from 3003-H14 sheet. Extruded shapes shall be 6063-T6, unless noted otherwise.
- All fasteners shall be zinc coated to prevent corrosion unless noted otherwise.
- All wall penetrations shall be sealed to prevent water intrusion.
- This design is prototypical and should not be used for site specific applications unless reviewed and deemed suitable for use at that site by a competent Professional Engineer.

APPROVAL SIGNATURE

DATE

By signing, you are validating the dimensions and graphic provided to SignResource and/or you are handling your own installation.




6135 District Blvd • Maywood, CA 90270  
800.423.4283 • Fax 323.560.7143  
Website: www.signresource.com

REVISION HISTORY:

REV	DATE	REQUESTED BY	UPDATED BY
A	06/27/13		BP
REVISION DESCRIPTION: INITIAL DRAWING RELEASE			
B	08/16/13		SCP
REVISION DESCRIPTION: REMOVED DUPLICATE COLOR CALLOUTS			
C	08/20/13		SCP
REVISION DESCRIPTION: ADDED 2ND EMBOSMENT DETAIL			


PARTS LIST:

ITEM	DECORATION
A	SPRAYLAT CB-2633 OR EQUIVALENT
E	SPRAYLAT BLACK OR EQUIVALENT
C	MATCH PMS COOL GRAY 5
D	METAL PAINT BLACK POLYURETHANE
E	
F	
MATERIAL LIST	

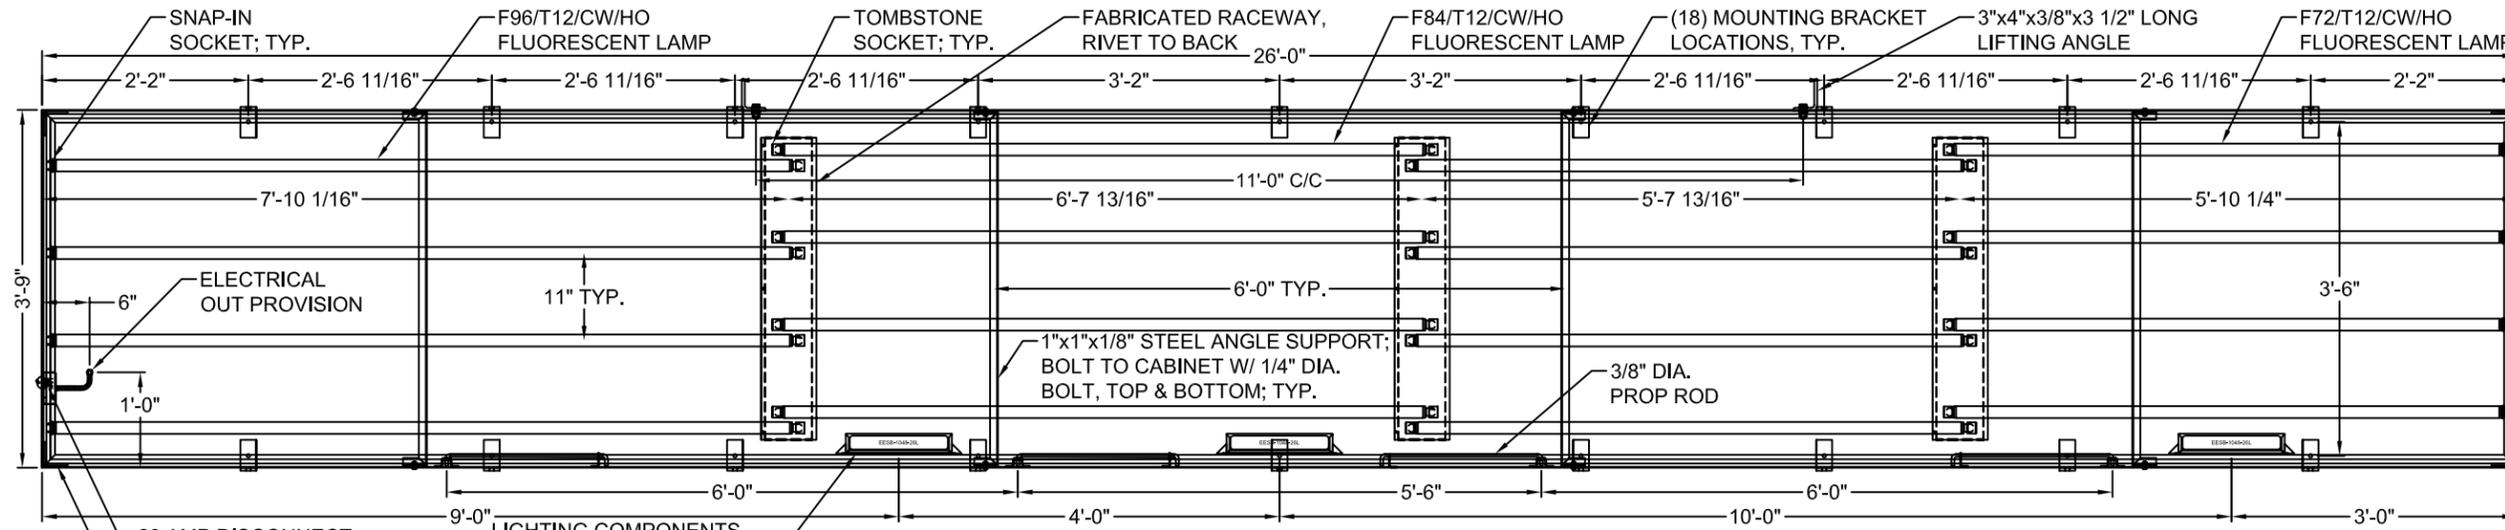


(2) 1/4" DIA. WEEP HOLES REQ'D @ EACH END OF CABINET

INTERIOR OF CABINET TO BE PAINTED LACRYL STARBRITE WHITE. RAW EDGES OR UNCOATED SURFACES SHALL NOT BE USED.

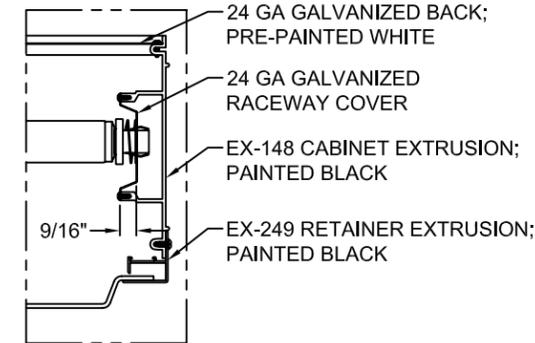

**ELECTRICAL REQUIREMENTS:**

LAMPS: (8) F72/T12/CW/HO FLUORESCENT LAMP  
(4) F84/T12/CW/HO FLUORESCENT LAMP  
(4) F96/T12/CW/HO FLUORESCENT LAMP  
BALLAST: (3) LIGHTING COMPONENTS EESB-1048-26L @ 2.5 AMPS  
TOTAL LOAD: 7.5A @ 120VAC  
CIRCUITS: (1) 20 AMP REQUIRED

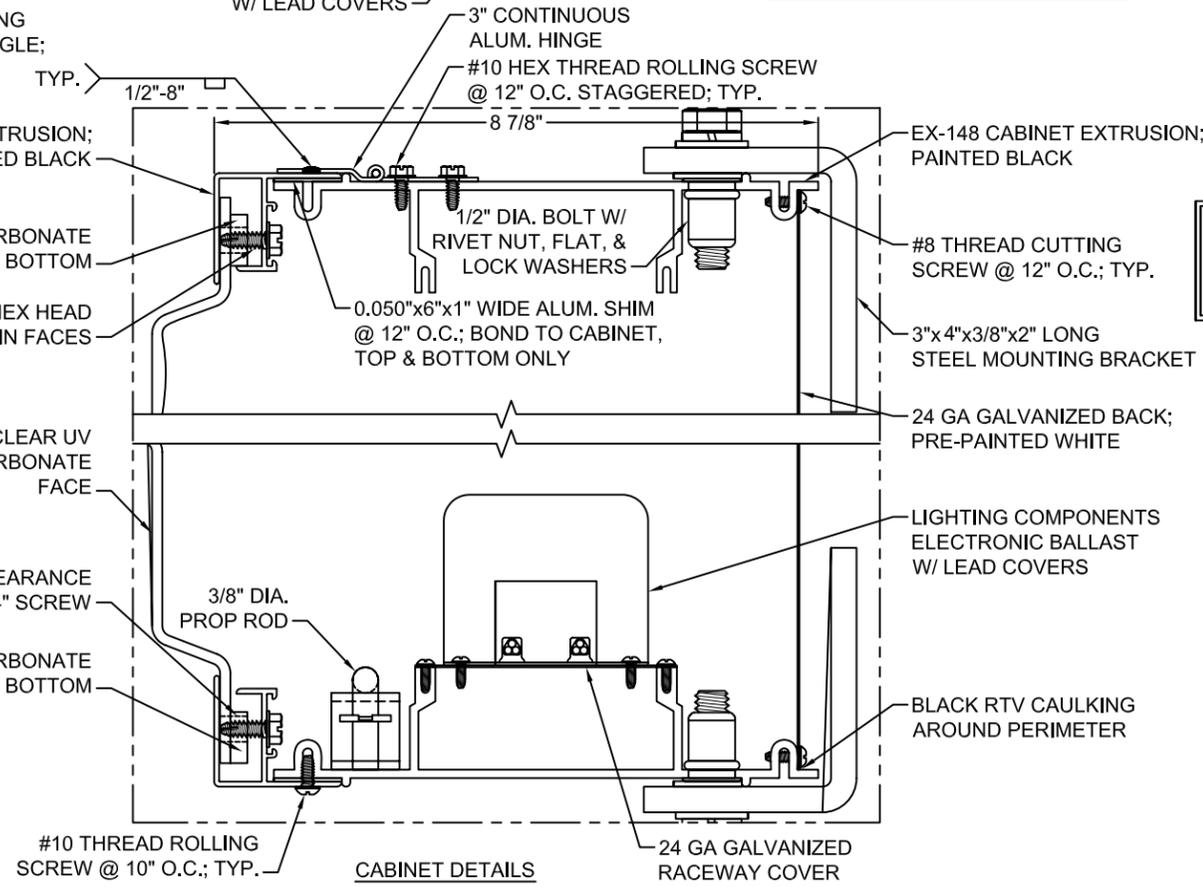

GENERAL NOTES

- TOLERANCE (UNLESS NOTED)
  - GRAPHICS +/- 1/8" • FACE SIZE + 1/16" - 1/4"
  - CABINET +/- 1/8" • VINYL OVERLAP + 1/8" +/- 1/16"
  - ALL COPY LEVEL UNLESS NOTED OTHERWISE
- VIEWING DISTANCE 25' TO 50' UNLESS NOTED OTHERWISE
- PMS COLOR CALLOUT INDICATES USE OF SPRAYLAT MIX SYSTEM
- NO DEVIATION OR MATERIAL SUBSTITUTION WITHOUT ECN.
- ALL ELECTRICAL SIGNS TO COMPLY WITH UL 48

DESCRIPTION			
DOLLAR GENERAL SF IL WALL CABINET			
3'9" X 26' 140MPH			
VOLTAGE:	CIRCUIT:	CURRENT:	DESIGN LOAD:
DRAWN BY:		CHECKED BY:	
B.PERRY			
CLIENT: DOLLAR GENERAL			
LOCATION: VARIOUS			
QUOTE: VARIOUS	DATE:	07/08/13	
DRAWING/PART #	REV.	SHEET #	
DG0426W02	D	3 OF 4	

This document reflects trade secrets and confidential business information, and may not be copied, published, or disseminated in any manner without the prior express written approval of SignResource. All rights reserved, including patent.

APPROVAL SIGNATURE

DATE

By signing, you are validating the dimensions and graphic provided to SignResource and/or you are handling your own installation.



6135 District Blvd • Maywood, CA 90270  
800.423.4283 • Fax 323.560.7143  
Website: www.signresource.com

REVISION HISTORY:

REV	DATE	REQUESTED BY	UPDATED BY
A	06/27/13		BP
REVISION DESCRIPTION INITIAL DRAWING RELEASE			
B	08/16/13		SCP
REVISION DESCRIPTION REMOVED DUPLICATE COLOR CALLOUTS			
C	08/20/13		SCP
REVISION DESCRIPTION ADDED 2ND EMBOSMENT DETAIL			

PARTS LIST:

ITEM	DECORATION
A	SPRAYLAT CB-2633 OR EQUIVALENT
E	SPRAYLAT BLACK OR EQUIVALENT
C	MATCH PMS COOL GRAY 5
D	METAL PAINT BLACK POLYURETHANE
E	
F	
MATERIAL LIST	
1	
2	
3	
4	
5	




THIS SIGN IS INTENDED TO BE INSTALLED IN ACCORDANCE WITH THE REQUIREMENTS OF ARTICLE 600 OF THE NATIONAL ELECTRIC CODE AND/OR OTHER APPLICABLE LOCAL CODES. THIS INCLUDES PROPER GROUNDING AND BONDING OF THE SIGN

GENERAL NOTES

1. TOLERANCE ( UNLESS NOTED )
  - GRAPHICS +/- 1/8" • FACE SIZE + 1/16" - 1/4"
  - CABINET +/- 1/8" • VINYL OVERLAP + 1/8" +/- 1/16"
  - ALL COPY LEVEL UNLESS NOTED OTHERWISE
2. VIEWING DISTANCE 25' TO 50' UNLESS NOTED OTHERWISE
3. PMS COLOR CALLOUT INDICATES USE OF SPRAYLAT MIX SYSTEM
4. NO DEVIATION OR MATERIAL SUBSTITUTION WITHOUT ECN.
5. ALL ELECTRICAL SIGNS TO COMPLY WITH UL 48


DESCRIPTION			
DOLLAR GENERAL SF IL WALL CABINET 3'9" X 26' 140MPH			
VOLTAGE:	CIRCUIT:	CURRENT:	DESIGN LOAD:
DRAWN BY: B. PERRY		CHECKED BY:	
CLIENT: DOLLAR GENERAL			
LOCATION: VARIOUS			
QUOTE:	VARIOUS	DATE:	07/08/13
DRAWING/PART #	REV.	SHEET #	
DG0426W02	D	4 OF 4	

This document reflects trade secrets and confidential business information, and may not be copied, published, or disseminated in any manner without the prior express written approval of SignResource. All rights reserved, including patent.

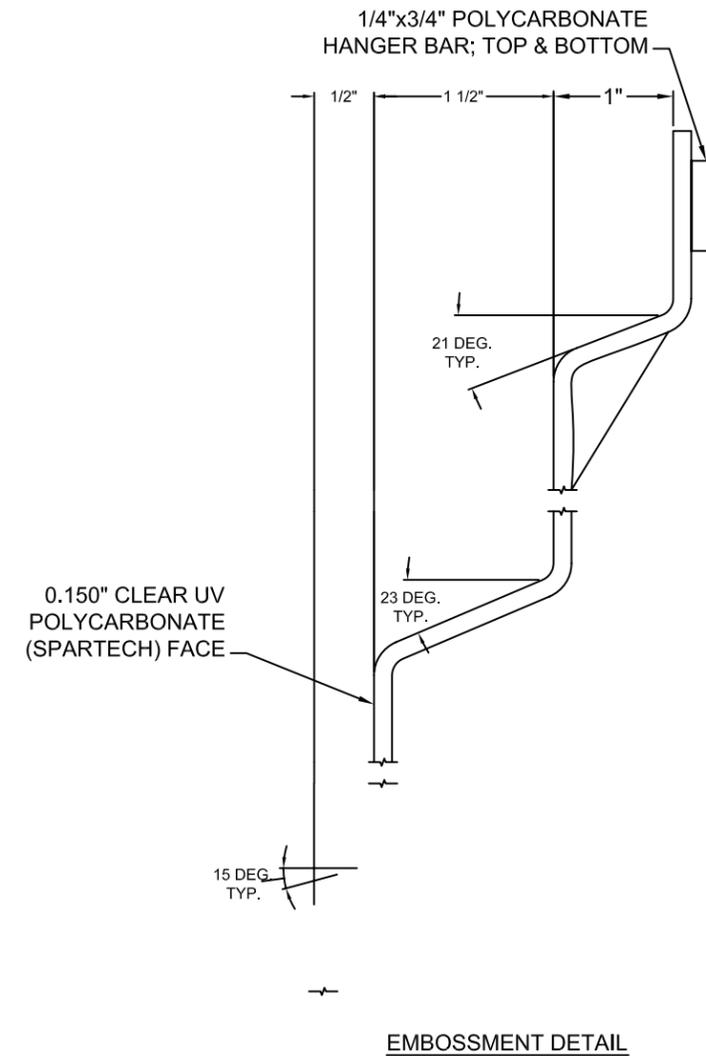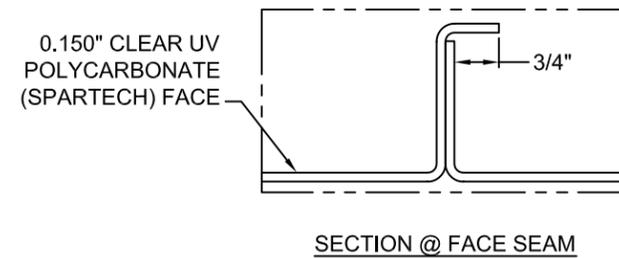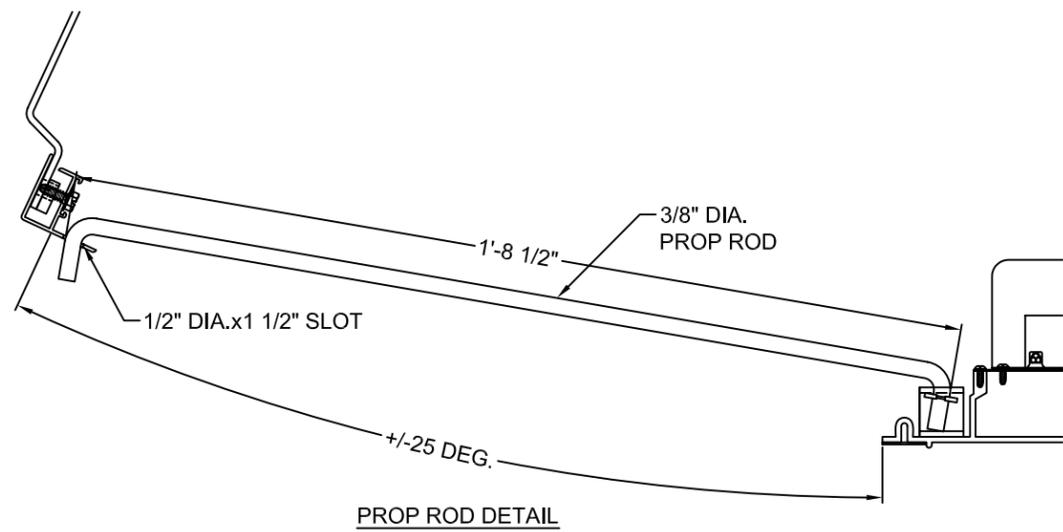



ILLUMINATION VIEW

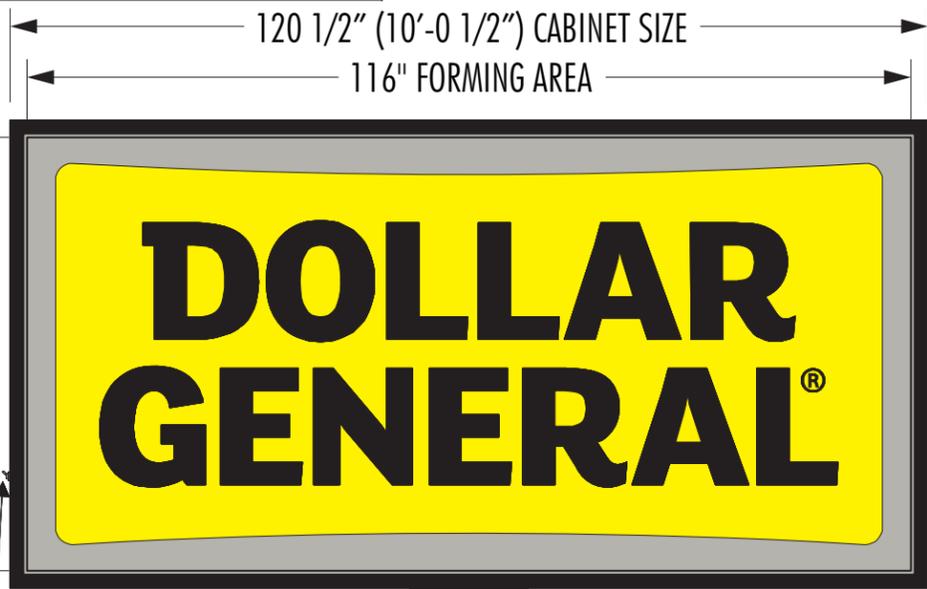


DISCONNECT SWITCH

SEE PLATE DETAIL

APPROVAL SIGNATURE \_\_\_\_\_ DATE \_\_\_\_\_  
 By signing, you are validating the dimensions and graphic provided to SignResource and/or you are handling your own installation.

COLOR SPECIFICATIONS

Yellow:	match Spraylat C8-2633
Brushed Aluminum:	match Spraylat FM-171
Black (Copy):	match Spraylat Black
Satin Black (Metal):	match Black Polyurethane
Cool Gray:	match PMS Cool Gray 5
Rock Bottom Gray:	match Sherwin Williams SW7062
Green:	match PMS 368C

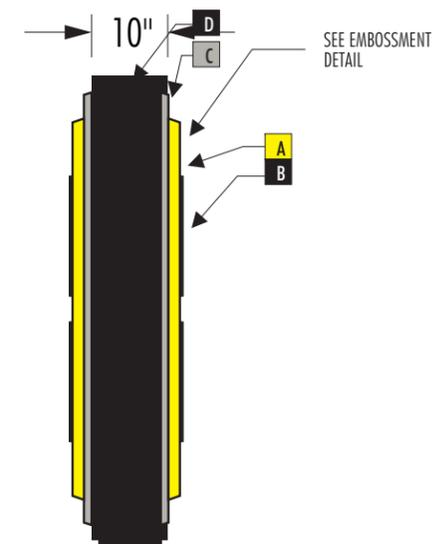

SEE EMBOSSMENT DETAIL

**SignResource**  
 IDENTITY GROUP  
 6135 District Blvd • Maywood, CA 90270  
 800.423.4283 • Fax 323.560.7143  
 Website: www.signresource.com

REVISION HISTORY:

REV	DATE	REQUESTED BY	UPDATED BY
D	05/01/14	AH	BS
REVISION DESCRIPTION: CHANGED HEIGHT TO 5'-0 1/2"			
E	01/23/17	TL	BS
REVISION DESCRIPTION: UPDATED PLATE DETAILS			
F	02/06/17	TL	BS
REVISION DESCRIPTION: UPDATED CABINET TO MATCH CAD			

PARTS LIST:

ITEM	DECORATION
A	SPRAYLAT C8-2633 OR EQUIVALENT
B	SPRAYLAT BLACK OR EQUIVALENT
C	MATCH PMS COOL GRAY 5
D	METAL PAINT BLACK POLYURETHANE
E	
F	


MATERIAL LIST

1
2
3
4
5


THIS SIGN IS INTENDED TO BE INSTALLED IN ACCORDANCE WITH THE REQUIREMENTS OF ARTICLE 600 OF THE NATIONAL ELECTRIC CODE AND/OR OTHER APPLICABLE LOCAL CODES. THIS INCLUDES PROPER GROUNDING AND BONDING OF THE SIGN

GENERAL NOTES


- TOLERANCE (UNLESS NOTED)
  - GRAPHICS +/- 1/8" • FACE SIZE + 1/16" - 1/4"
  - CABINET +/- 1/8" • VINYL OVERLAP + 1/8" +/- 1/16"
  - ALL COPY LEVEL UNLESS NOTED OTHERWISE
- VIEWING DISTANCE 25' TO 50' UNLESS NOTED OTHERWISE
- PMS COLOR CALLOUT INDICATES USE OF SPRAYLAT MIX SYSTEM
- NO DEVIATION OR MATERIAL SUBSTITUTION WITHOUT ECN.
- ALL ELECTRICAL SIGNS TO COMPLY WITH UL 48

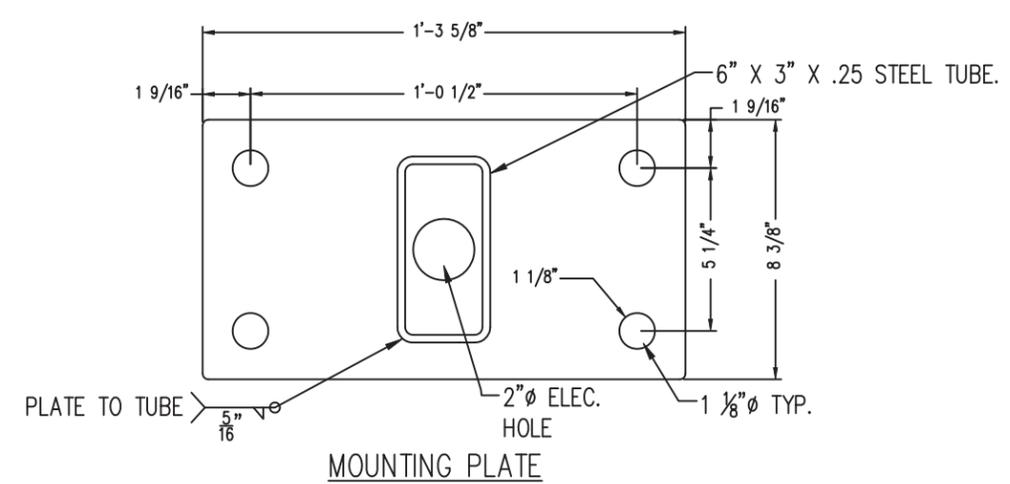

MOUNTING PLATE

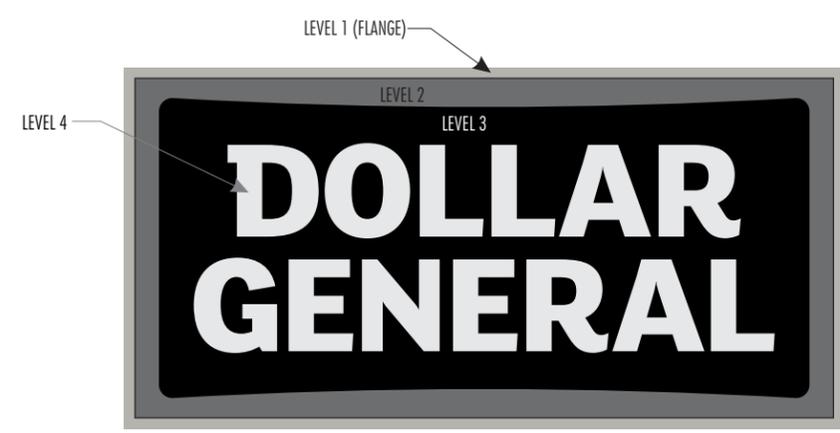

EMBOSSMENT LEVELS

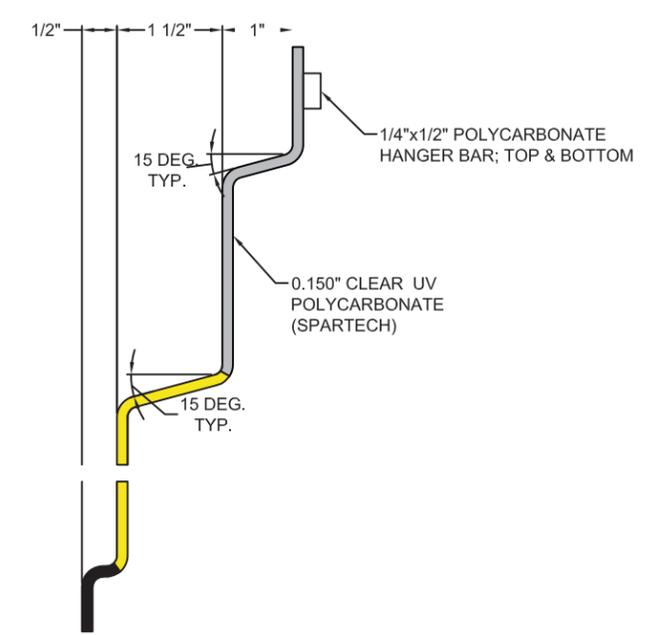

EMBOSSMENT DETAIL









DESCRIPTION			
DOLLAR GENERAL DF IL CENTER POLE PYLON SIGN 140 MPH WINDLOAD			
VOLTAGE:	CIRCUIT:	CURRENT:	DESIGN LOAD:
DRAWN BY: B. PERRY		CHECKED BY:	
CLIENT: DOLLAR GENERAL			
LOCATION: VARIOUS			
QUOTE: VARIOUS	DATE: 07/08/13		
DRAWING/PART #: DGO510C02	REV: F	SHEET #: 1 OF 3	

This document reflects trade secrets and confidential business information, and may not be copied, published, or disseminated in any manner without the prior express written approval of SignResource. All rights reserved, including patent, trademark and copyright.



P.O. Box 549 - Maywood CA 90270  
 800 423-4283 - 323 771-2098 - Fax 323 560-7143  
 Website: www.Signresource.net



RV.	DESCRIPTION	DATE	BY
A	INITIAL DRAWING RELEASE	08/07/13	JNV
B	UPDATED DRAWING	10/21/14	JNV
C	UPDATED EXTRUSION/RETAINERS	10/05/16	CR

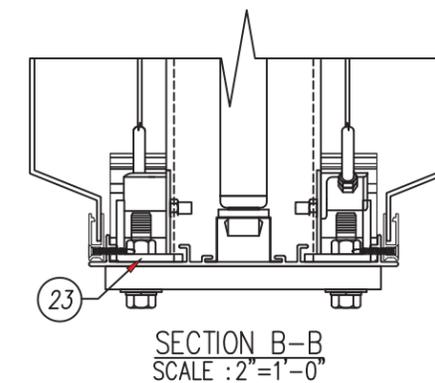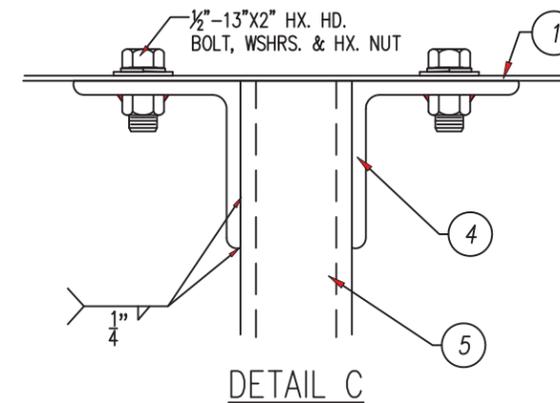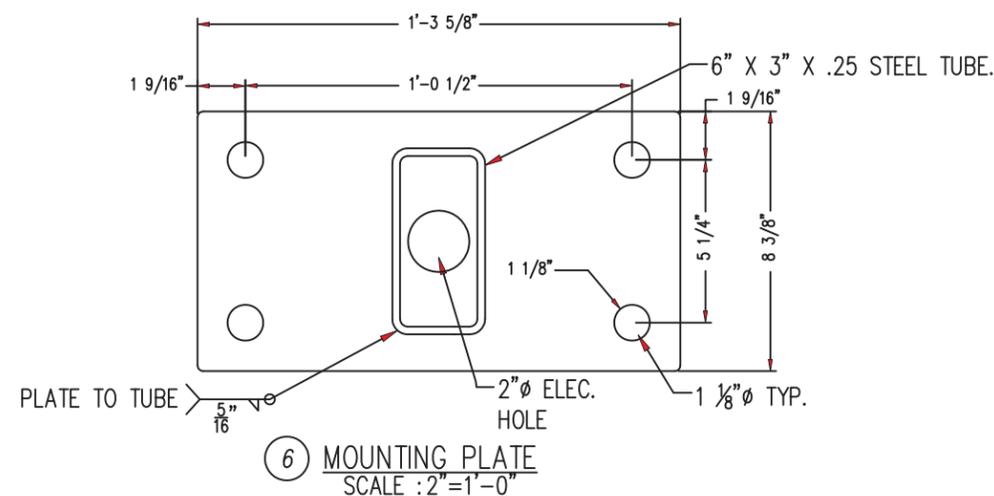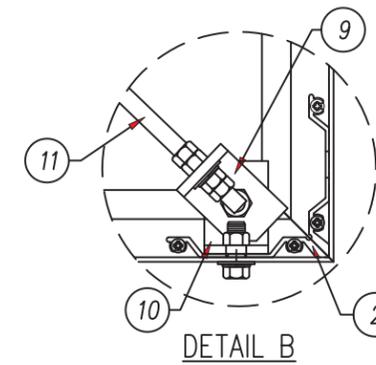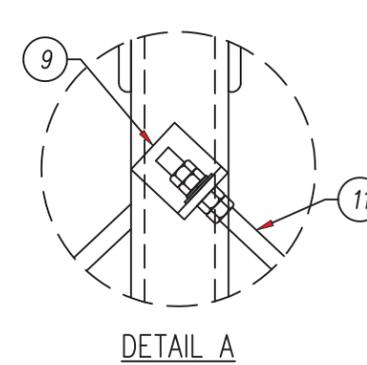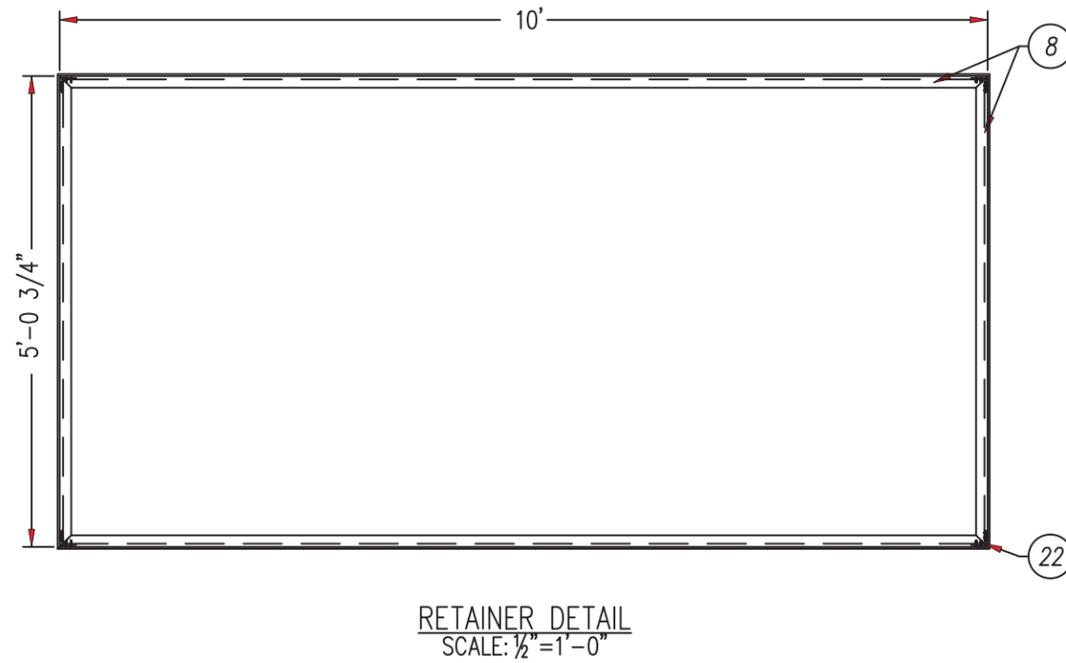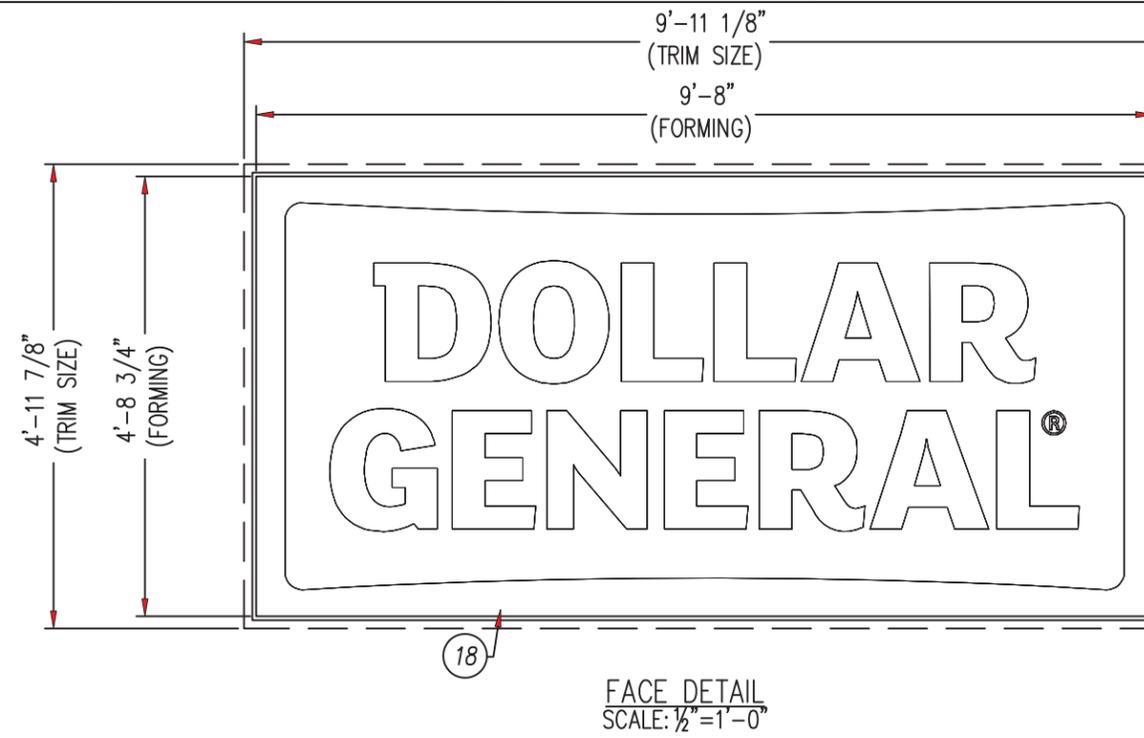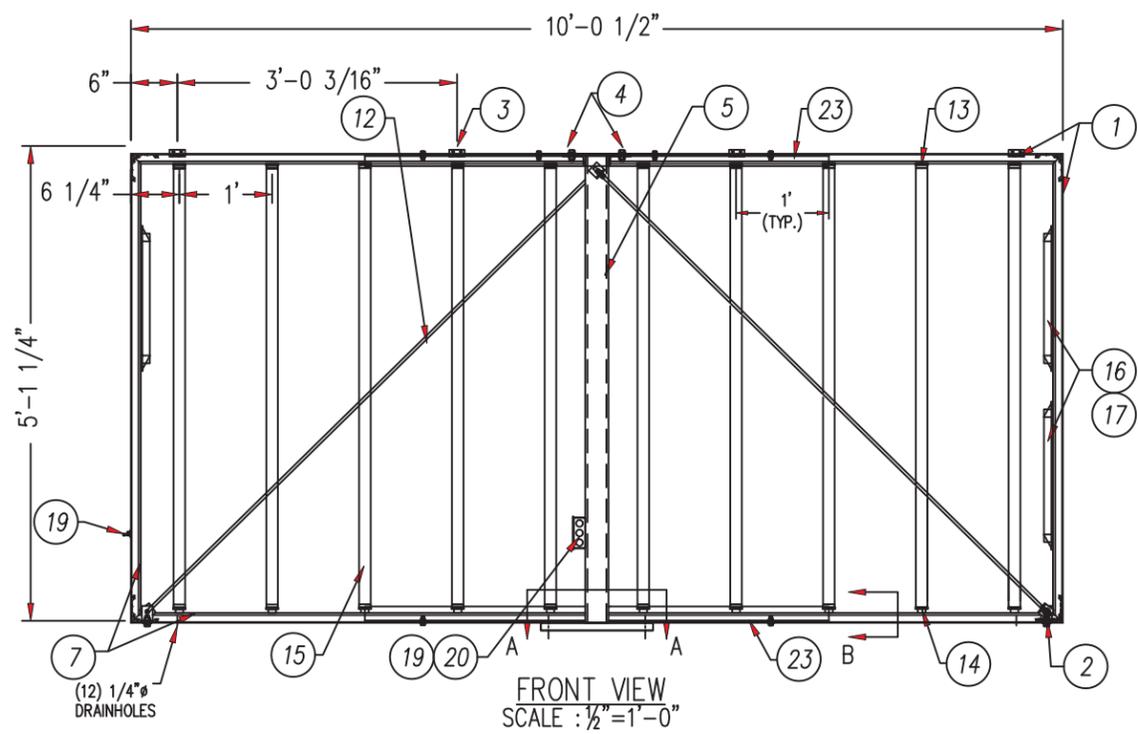

PARTS LIST			
NO	PART #	DESCRIPTION	QTY
1	OEXT009F10	10" ALUM. EXTRUSION FRAME SECT.	4
2	OMF03F	3.5" X 3.5" X 2 7/16"	8
3	OHIN000202	2" X 2" X .060" PIANO HINGE	4
4	OMF014	3" X 3" X 2" X 1/4" STEEL ANGLE	2
5	OSRT000018	6" X 3" X .250 STEEL RECT TUBE @ 59 5/8"	1
6	OSPL0815100	8 3/8" X 15 5/8" X 1" STEEL PLATE	1
7	OMF109	2.452" X 1.4375" X 120" GALV. HAT SECTION	6
8	OEXT009R15	1.5" STRAIGHT RETAINER	8
9	OSAN000203	1 1/2"X1 1/2"X3/16" STEEL ANGLE @ 1 1/2"	4
10	OEXT000406	2"X2"X1/8" ALUM. ANGLE @ 1-3/8"	2
11	OSRB037516	3/8"-16 X 12" THREADED STEEL ROD	2
12	OARR000003	.250" ALUMINUM SOLID ROD	2
13	OELH000001	T12 LAMPHOLDER BUTT-ON RECESSED	10
14	OELH000002	T12 LAMPHOLDER BUTT-ON SPRING	10
15	OLCW000007	F60T12 CW/HO FLUORESCENT LAMP	10
16	OBSO000023	SUN HORSE MODEL FEP-120-600-L	3
17	OMF022	ALUMINUM TEEPEES FOR BALLAST	6
18	OLEX15076	76" X .150" CLEAR POLYCARBONATE	2
19	OSW000002	RUBBER BOOTED TOGGLE SWITCH BLK.	1
20	OECF000017	1 1/2"X2 1/8"X4" HANDY BOX	1
21	OECF000100	2"X4" BLANK HANDY BOX COVER	1
22	OMF29R	2 X 2 X 0.30 CRNR KEY FOR RETAINER	8
23	OSAN000203	2 X 2 X 1/4" STEEL ANGLE @ 60°	4

Voltage	120 AC	Circuits	[1] ONE	Current	4.66 AMP	Drawn By	JNV	Date	08/07/13	
Description	5'-1 1/4"x10'-0 1/2" ILLUMINATED DOUBLE CENTER POLE SIGN CABINET								Checked By	
Sign Size	50.62 SQ FT	Design Load	140 PSF	Client	DOLLAR GENERAL	Page	1 OF 2			
Part Number	DG0510C02	Drawing No.	DG0510C02		Rev.	A				

This document reflects trade secrets and confidential business information, and may not be copied, published, or disseminated in any manner without the prior express written approval of SignResource. All rights reserved, including patent, trademark and copyrights.

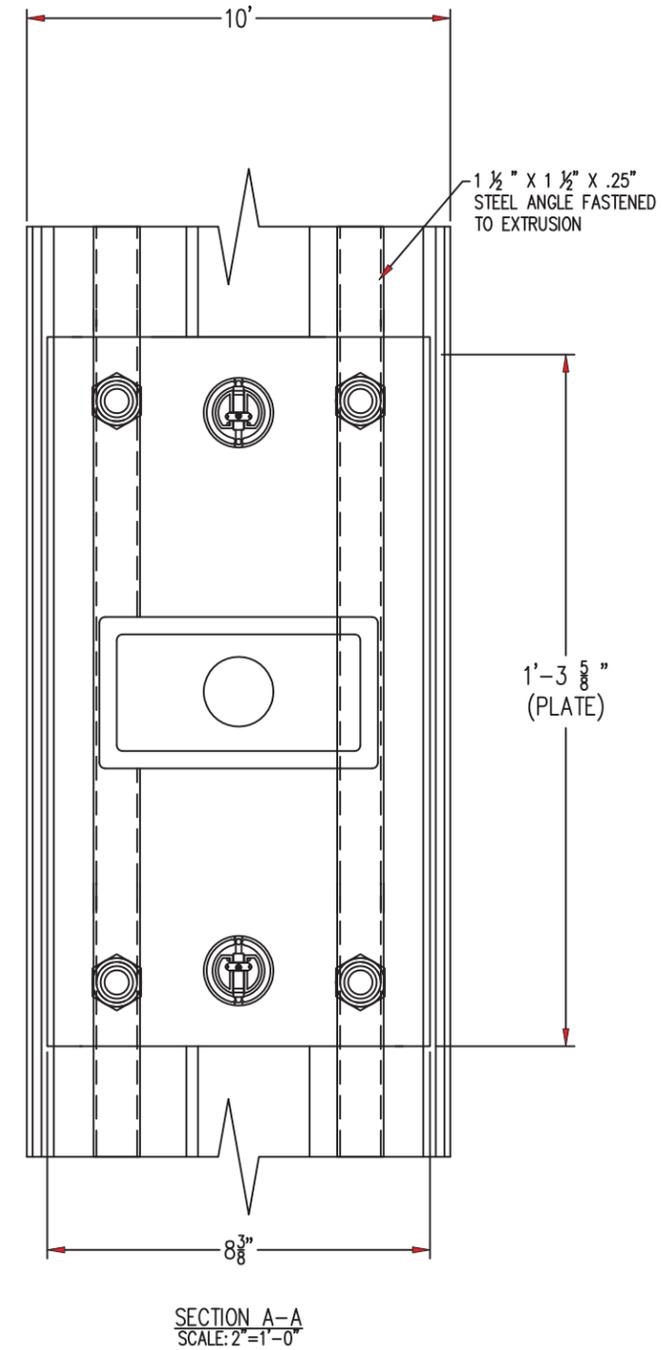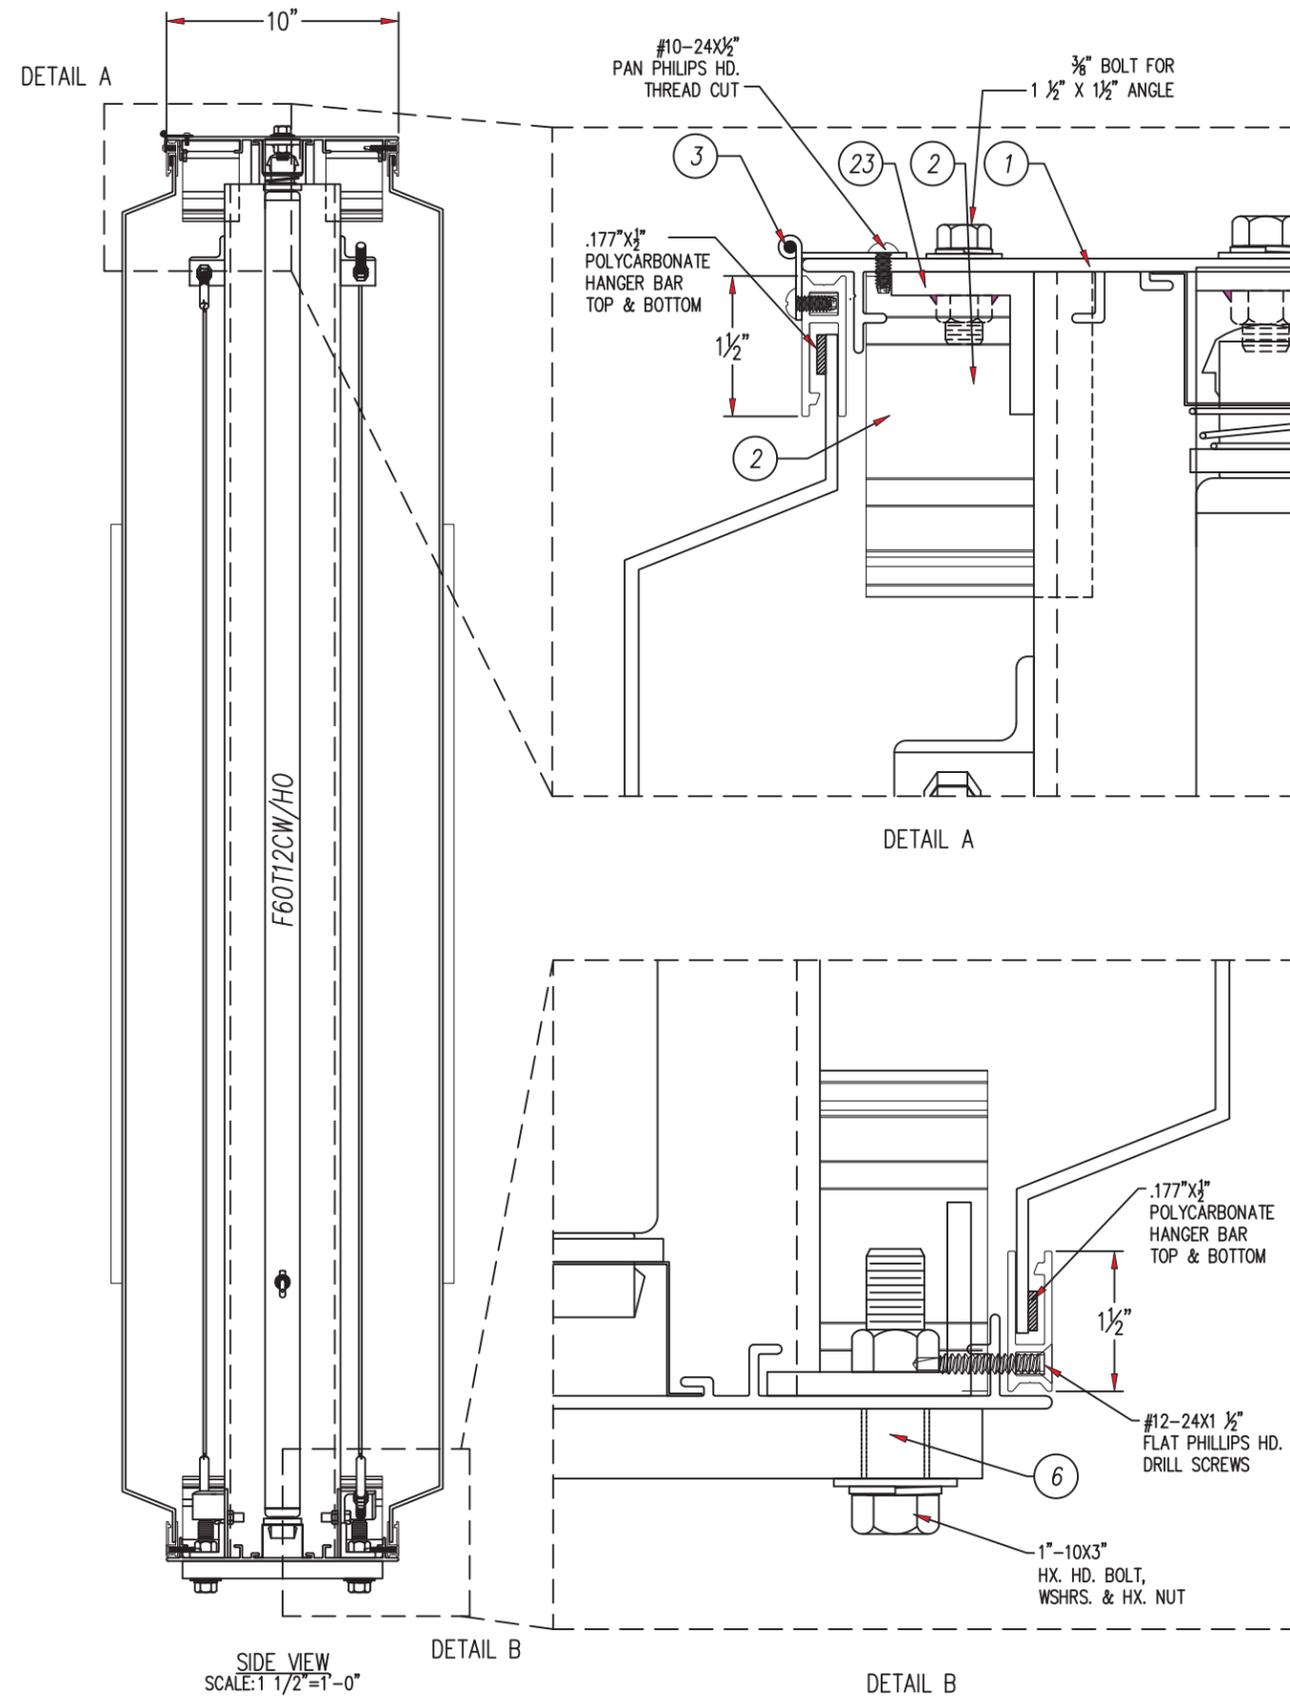

Voltage 120 AC	Circuits [1] ONE	Current 4.66 AMP	Drawn By JNV	Date 08/07/13
Description 5'-1 $\frac{1}{4}$ "x10'-0 $\frac{1}{2}$ " ILLUMINATED DOUBLE CENTER POLE SIGN CABINET				Checked By
Sign Size 50.62 SQ FT	Design Load 140 PSF	Client DOLLAR GENERAL	Page 2 OF 2	
Part Number DG0510C02	Drawing No. DG0510C02		Rev. A	